
PRELIMINARY

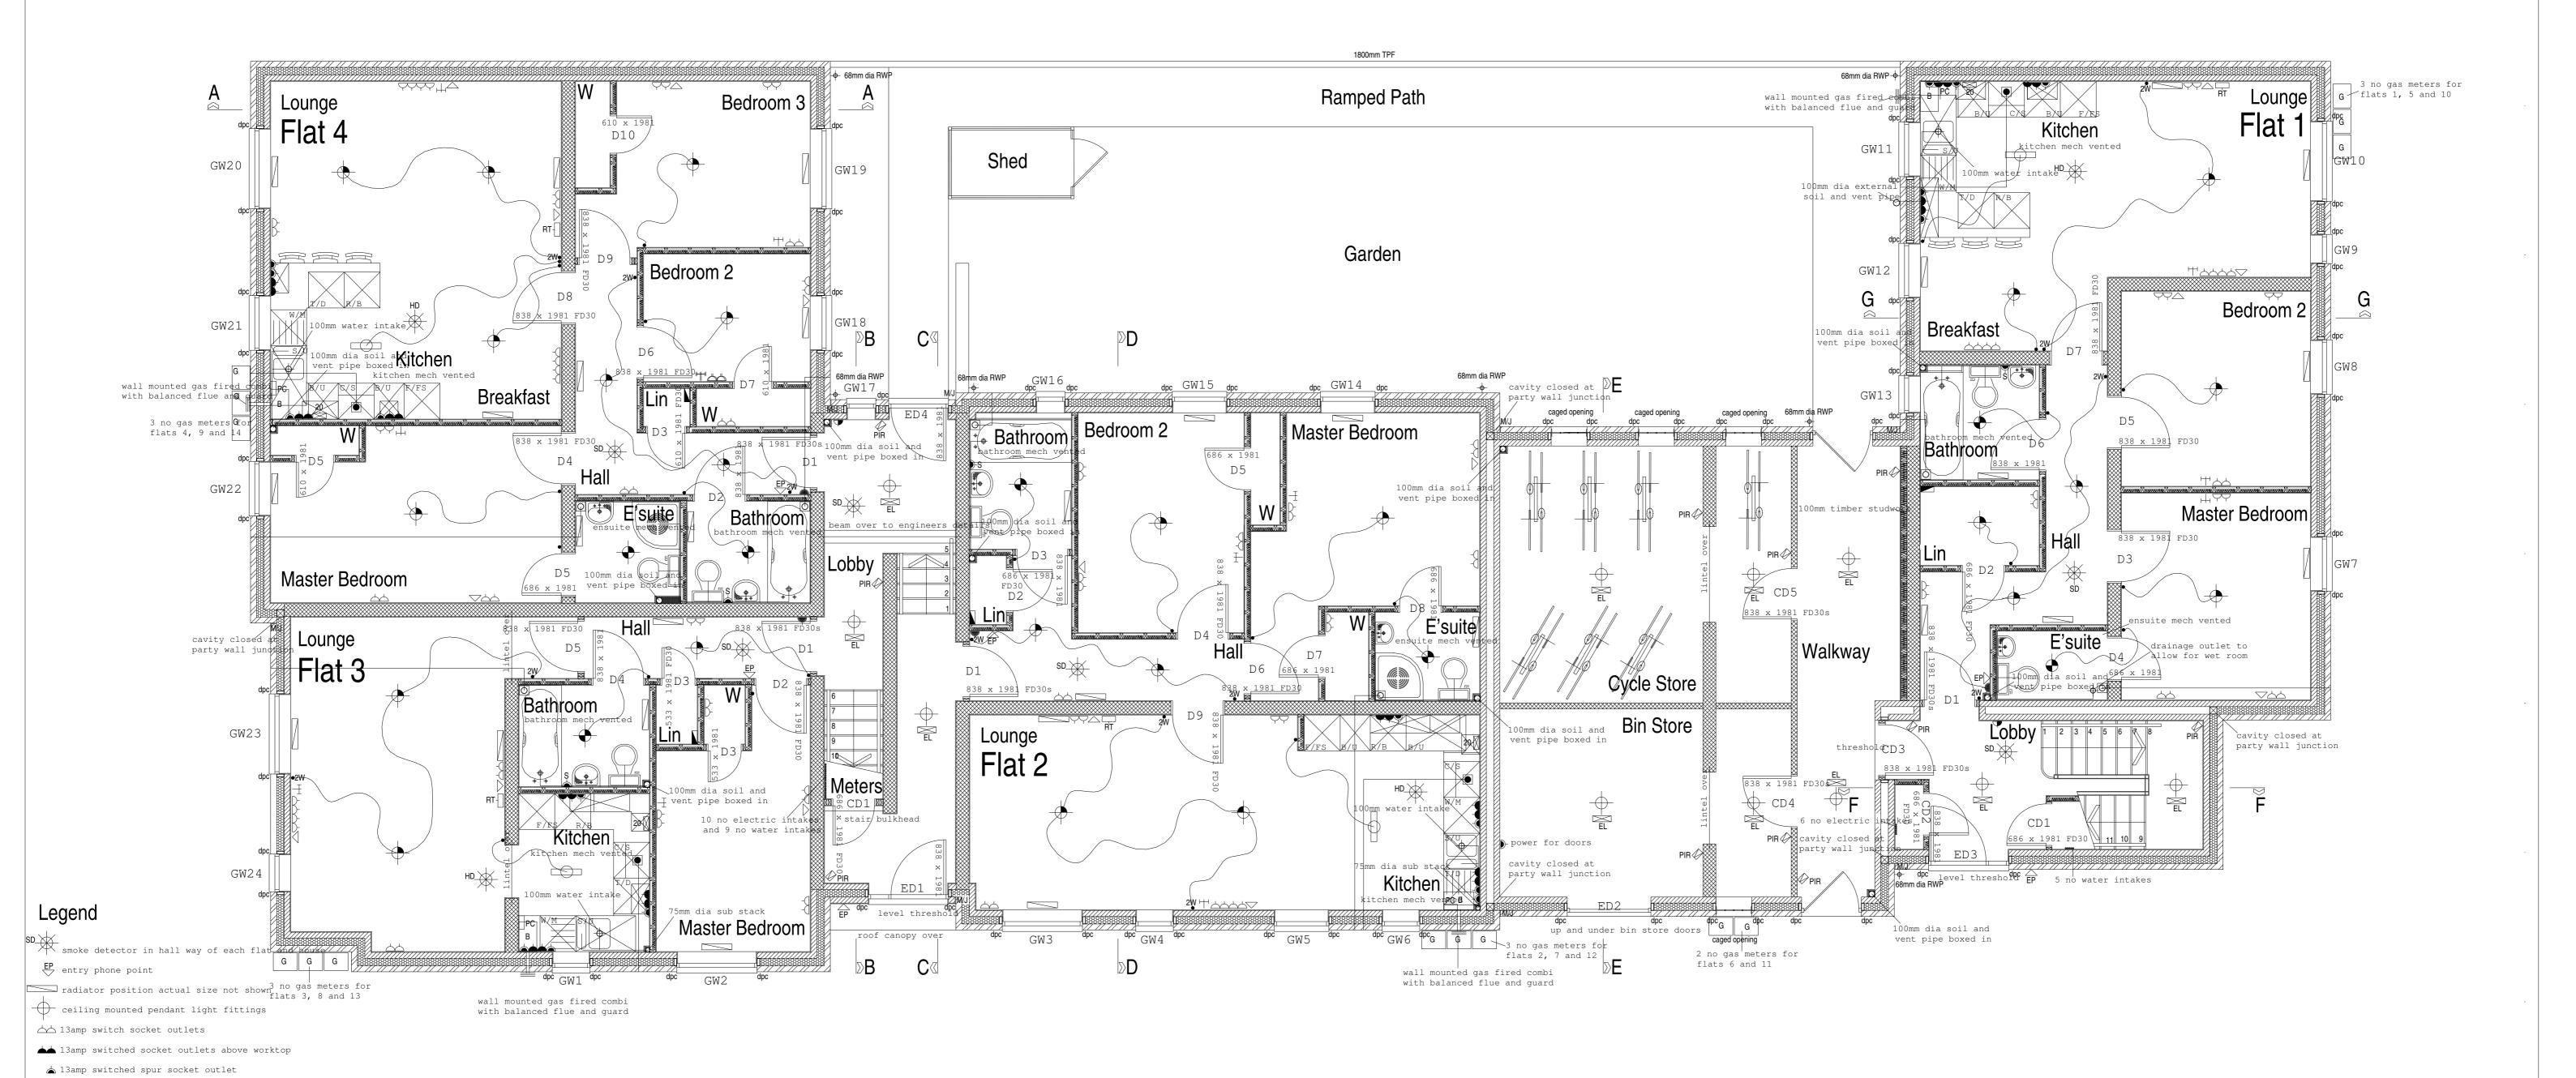

Proposed Residential Development

Wilder Street/Brunswick Street St Pauls Bristol Ground Floor Plan Scale 1: 50 @ A1 Date: Oct 2014

Date: Oct 2014
Drwg No 2598/100
David Cahill Design Consultant

PIR
PIR
emergency lighting

igtriangledown wall mounted telephone point

wall mounted light switch

ceiling mounted pull chord light switch

ceiling mounted thorn club bathroom light

ceiling mounted low energy light fitting and bulb

▲ 13 amp switched socket outlet off landlords supply operated

▲ spur for intruder alarm system in hall ways of flats

cooker panel for electric/gas cooker

ceiling mounted rail with 4 no spots

PC wall mounted gas boiler control panel

external wall mounted bulkhead light

from switch in meter cupboard

 \dashv wall mounted tv point

a shaver socket

extract fan

2W two way light switch

extract via cooker hood

high level consumer unit

RT wall mounted room thermastat